


N

TENDER PURPOSE ONLY

CHRISTIAN MEDICAL COLLEGE - VELLORE	
PROPOSED SIMULATION LABS AND CONFERENCE HALL ON THE FIRST FLOOR OF COLLEGE OF NURSING AT CMC CHITTOOR CAMPUS	
FIRST FLOOR PLAN - DEMOLITION PLAN	
DATE : 30.01.2026	DRG.NO. : CMC/SIMLAB/A-001
DRAWN : YAMUNA	CHECKED : DEVAKI
PLANNING ENGINEER:	

EXISTING SHOWN IN
DEMOLITION SHOWN IN

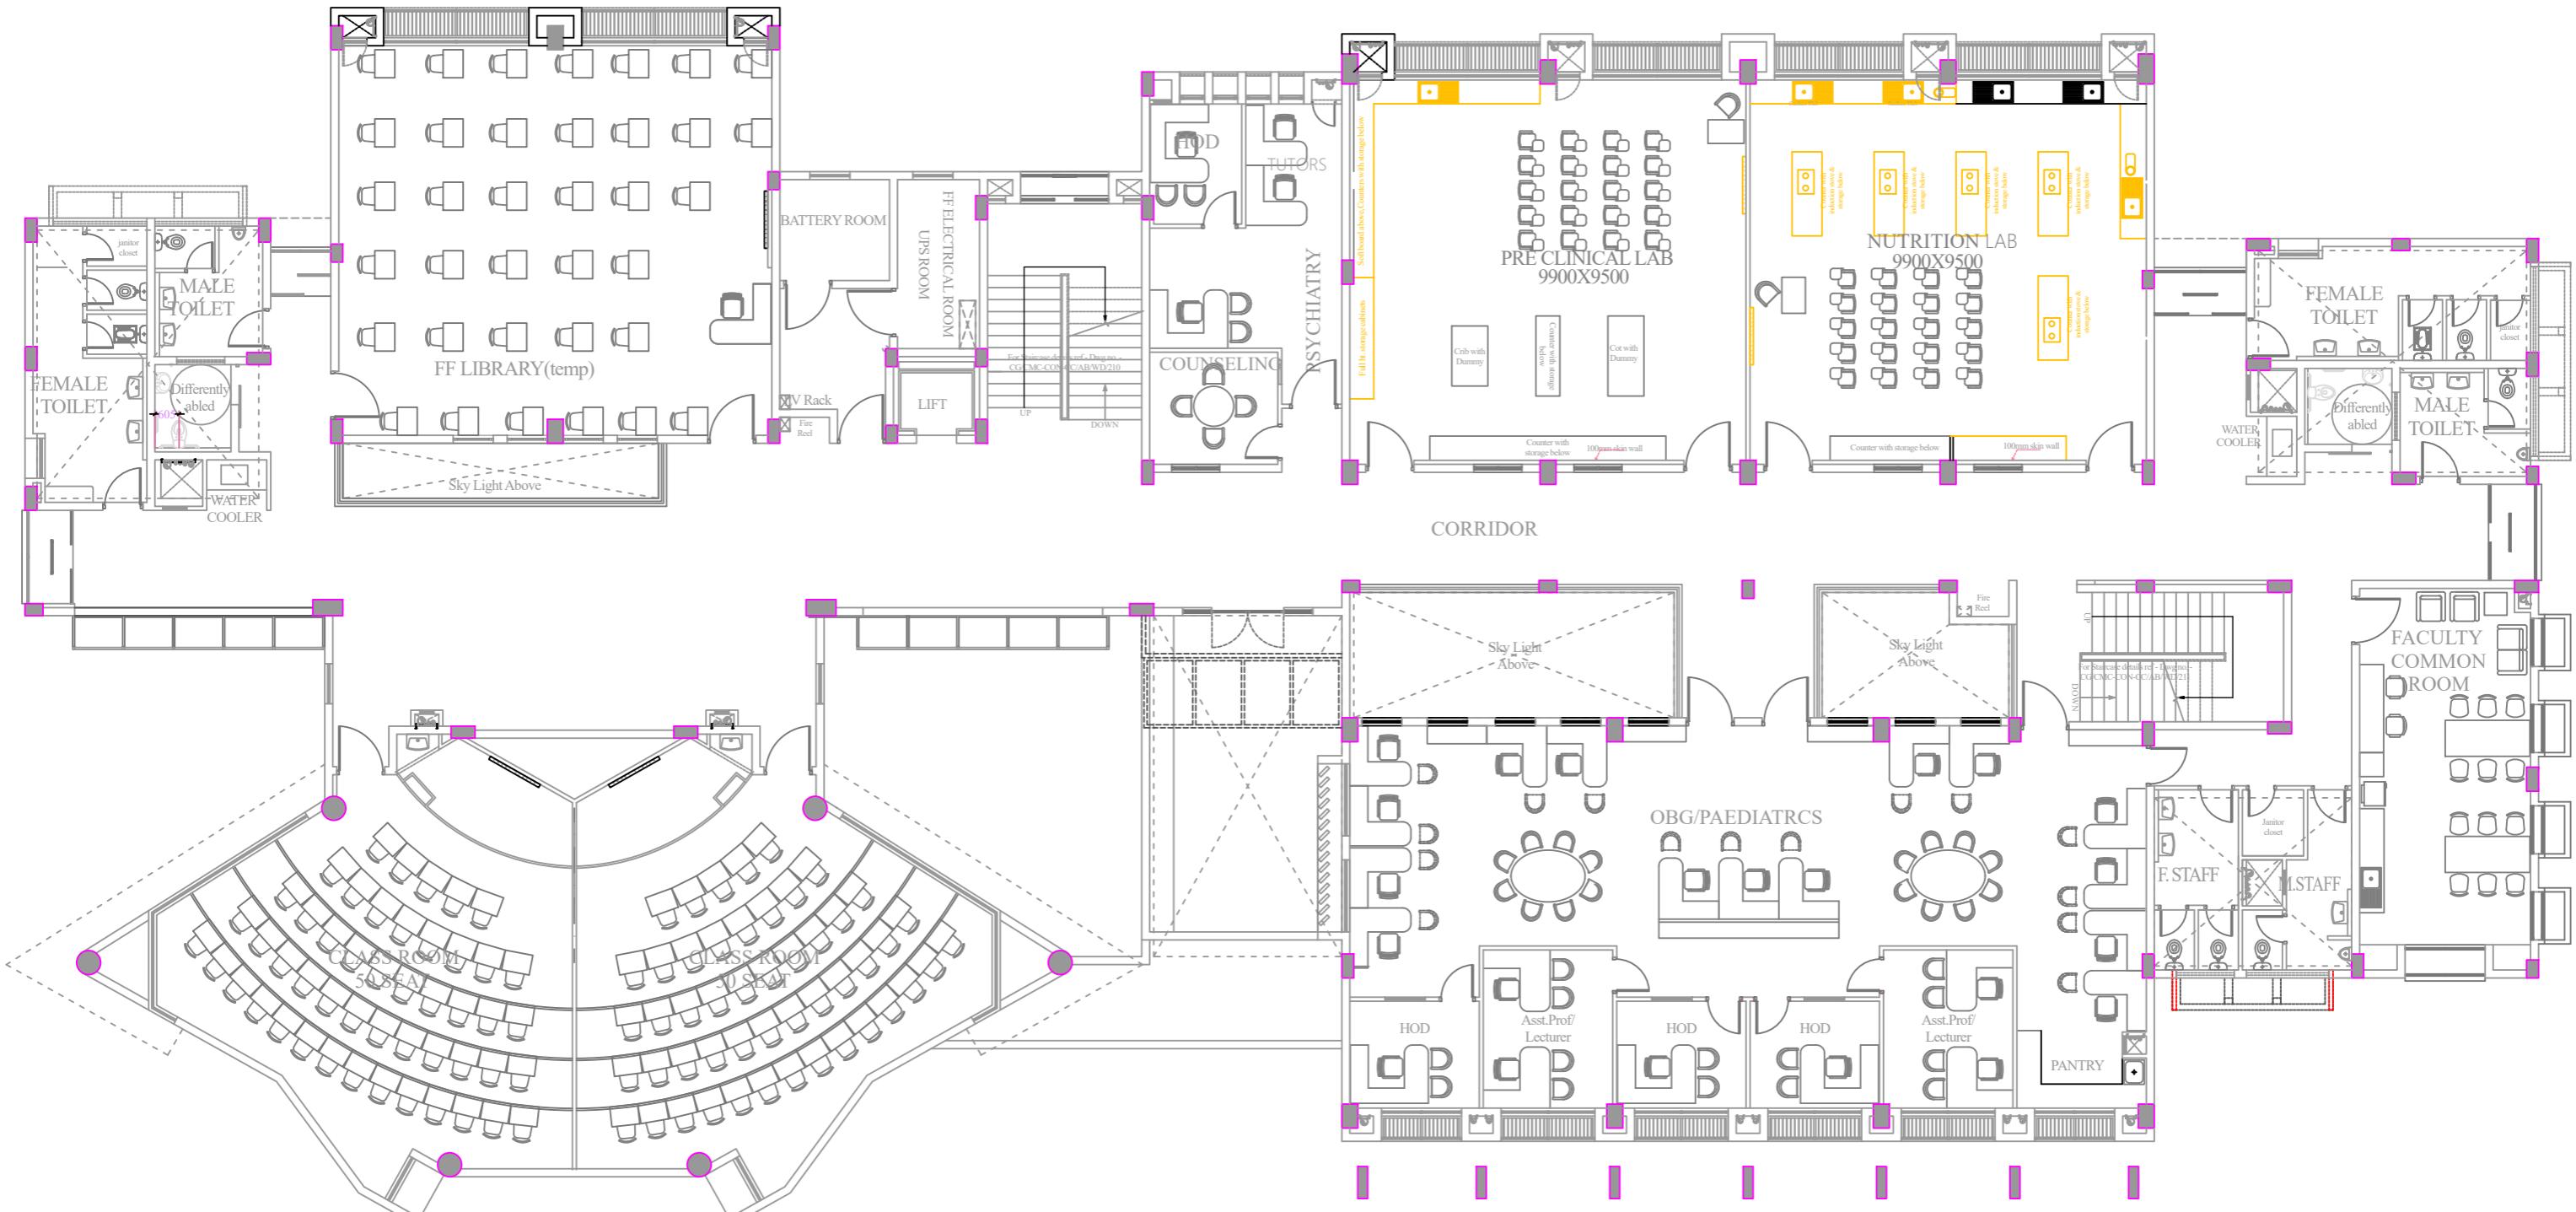