
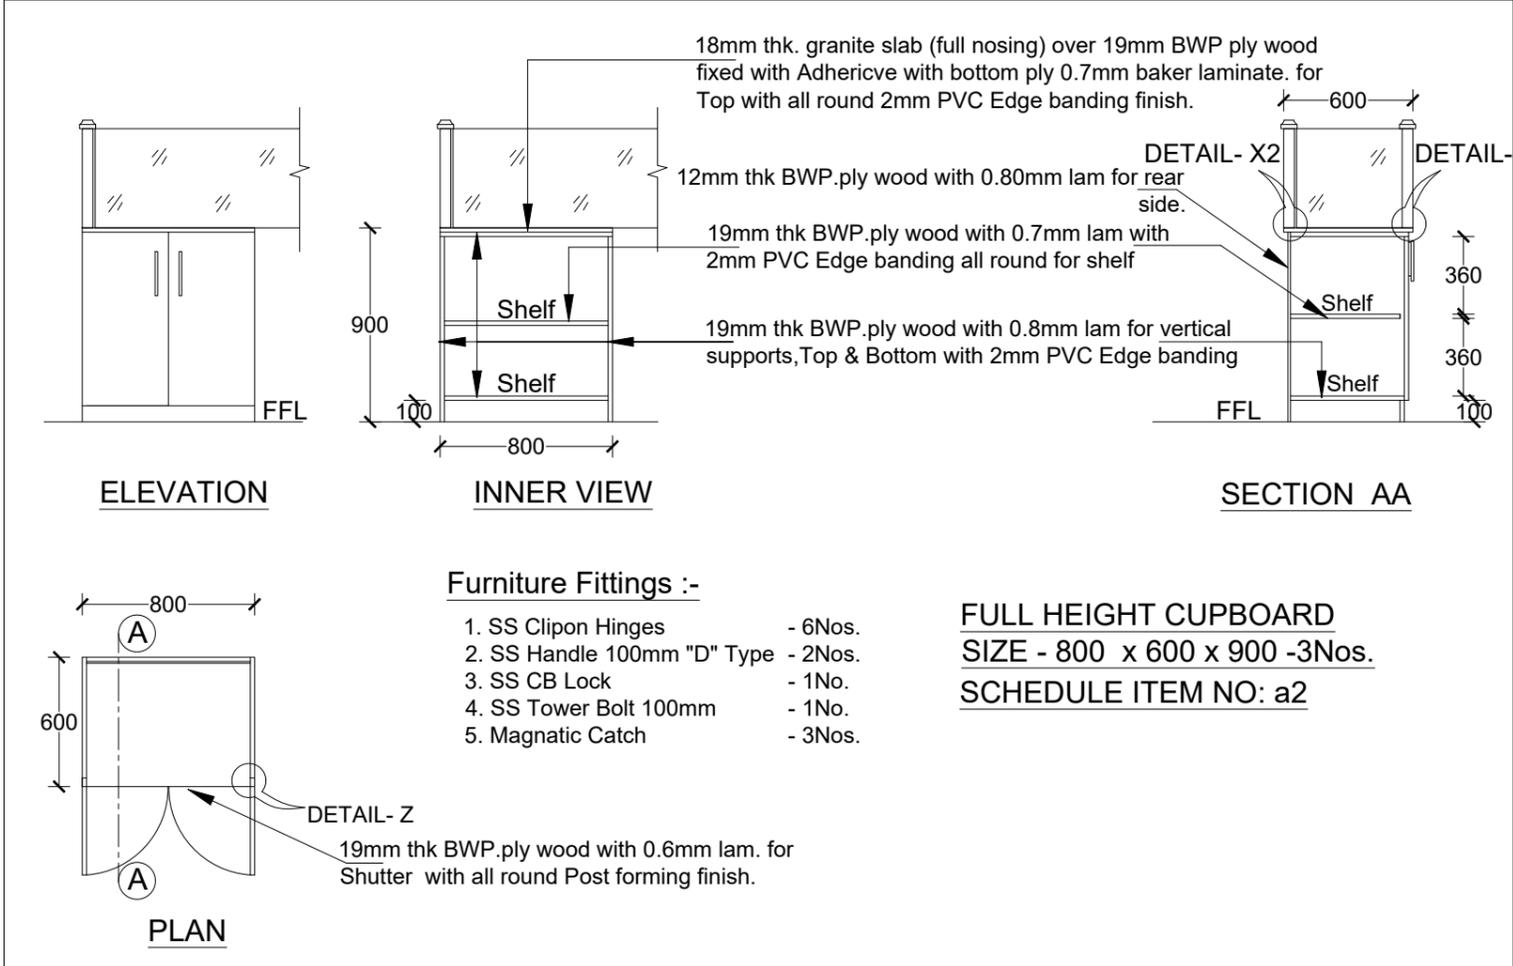


Furniture Fittings :

- 1. SS Clipon Hinges - 2Nos.
- 2. Telescopic Channel 400mm - 2Set.
- 3. Telescopic Channel 500mm - 1Set.
- 4. SS Handle 100mm "D" Type - 2Nos.
- 5. Hafele Lock & Key - 2Nos.





WORK TABLE WITH DRAWER / UNDER CUPBOARD / KEYBOARD
 2000 x 600 x 750 - 1No.
 SCHEDULE ITEM NO:a1

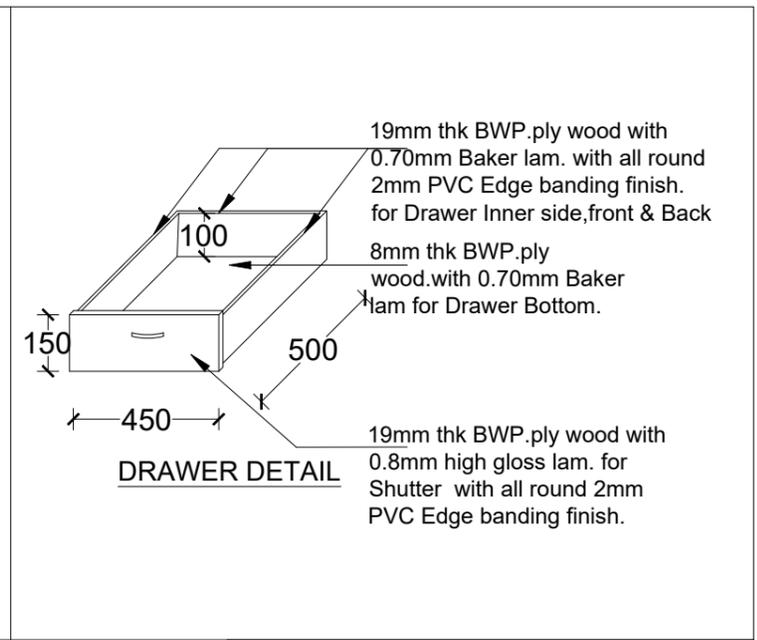

Furniture Fittings :-

- 1. SS Clipon Hinges - 6Nos.
- 2. SS Handle 100mm "D" Type - 2Nos.
- 3. SS CB Lock - 1No.
- 4. SS Tower Bolt 100mm - 1No.
- 5. Magnatic Catch - 3Nos.

FULL HEIGHT CUPBOARD
 SIZE - 800 x 600 x 900 -3Nos.
 SCHEDULE ITEM NO: a2

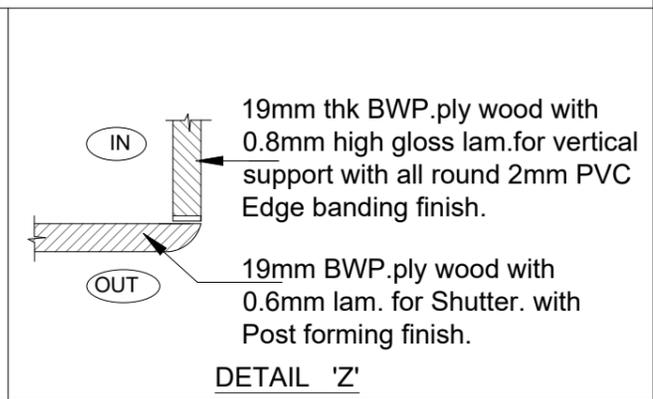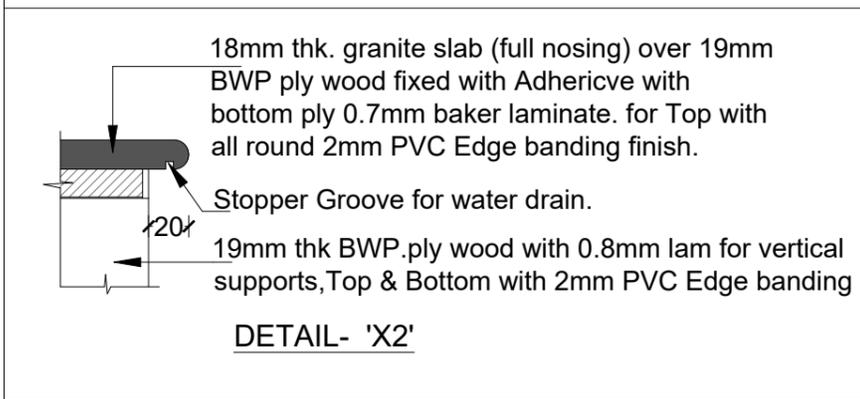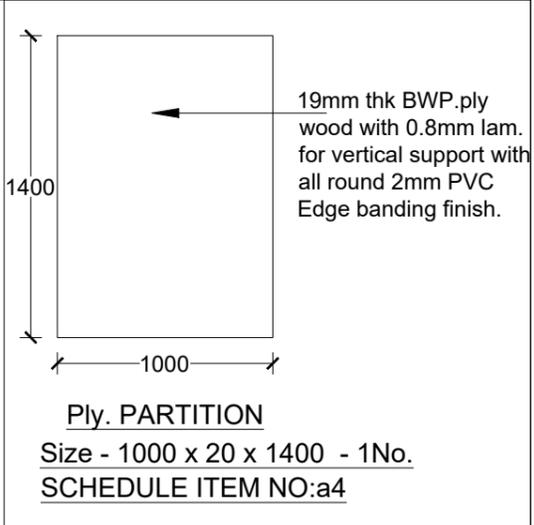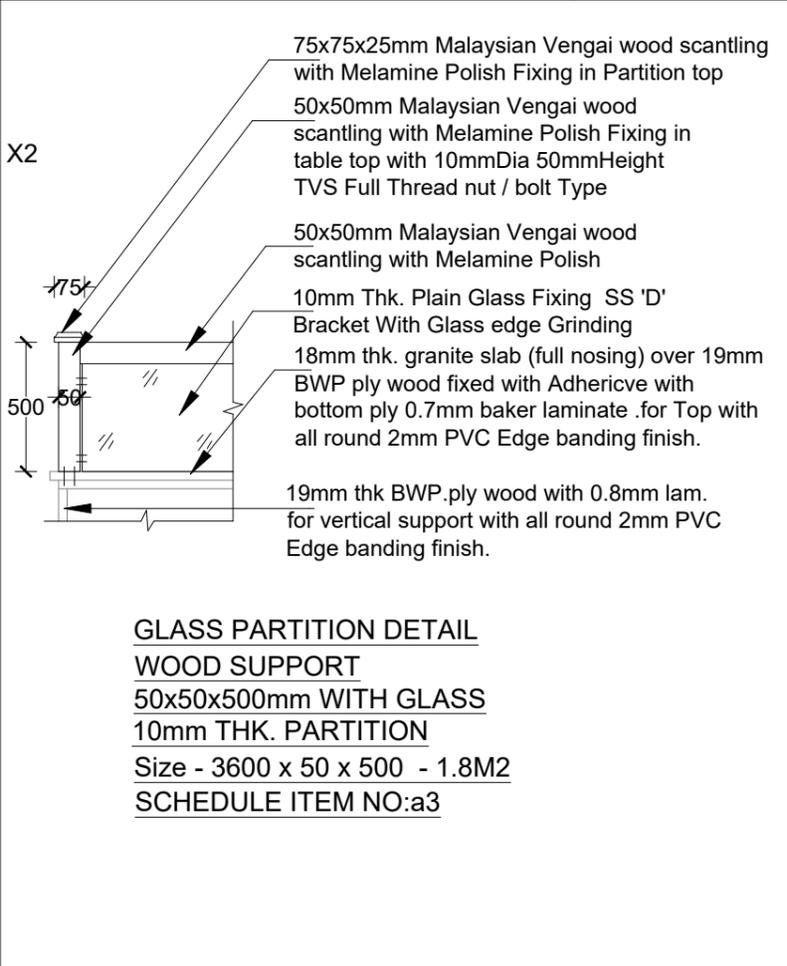

TENDER PURPOSE ONLY

CHRISTIAN MEDICAL COLLEGE -VELLORE.		
PROPOSED RENOVATION OF EXISTING H- WARD IN FIRST FLOOR CMC TOWN CAMPUS		
H WARD FIRST FLOOR PLAN		
NURSING STATION FURNITURE DETAILS		
CHECKED:DEVAKI.G	DATE :03.03.2026	PLANNING ENGINEER:
DRAWN: DHINAKARAN.I	DRG.NO:CMC/HW/F.002	